

### PUMPER BODY

Pumper, Med, Alum, 2nd Gen

### CHASSIS

Arrow XT Chassis

### CHASSIS AXLE, FRONT, CUSTOM

Axle, Front, Oshkosh TAK-4, Non Drive, 22,800 Lb, Qtm/AXT/DCF

### CHASSIS AXLE, REAR

Axle, Rear, Meritor RS24-160, 24,000 Lb

### ENGINE

DDC DD13, 500 hp, 1650 Ft-Lb, W/OBD, EPA 2013

### TRANSMISSION

Trans, Allison 5th Gen, 4000 EVS P, With Prognostics

### BUMPER

Bumper, 19" Extended, AXT, Dash CF

### CAB

Cab, Arrow XT 2010, 6710 Raised Roof

### HANDRAILS, CAB INTERIOR

Grab Handles, Driver Side Low & Officer Dash Panel

### BODY WATER TANK

Tank, Water, 750 Gallon, Poly, Med

### COMPT, PUMPER, REAR

Rear, RollUp, 44.50" FF

CUBIC FT:

### COMPT, PUMPER, DRIVER SIDE

DS 152" RollUp, Full Height Front & Rear, FDLER

D.S. CUBIC FT:

### COMPT, PUMPER PASS. SIDE

PS 152" RollUp, Full Height Front & Rear, FDLER

P.S. CUBIC FT:

### FIRE SUPPRESSION PUMPHOUSE

Pump House, Side Control, 45"

### PUMP

Pump, Waterous, CSU, 1500 GPM, Single Stage

### CROSSLAYS, 1.50"

Crosslays Sngl Sheet unpainted, (2+) 1.50", Std. Cap


### GENERATOR

Harrison 6kW MSV, Hydraulic, Hotshift PTO, Volt Meter Only




### DELUGE

Outlet, 3.00" NPT Deluge Riser

### SIDE ROLL AND FRONTAL IMPACT PROTECTION

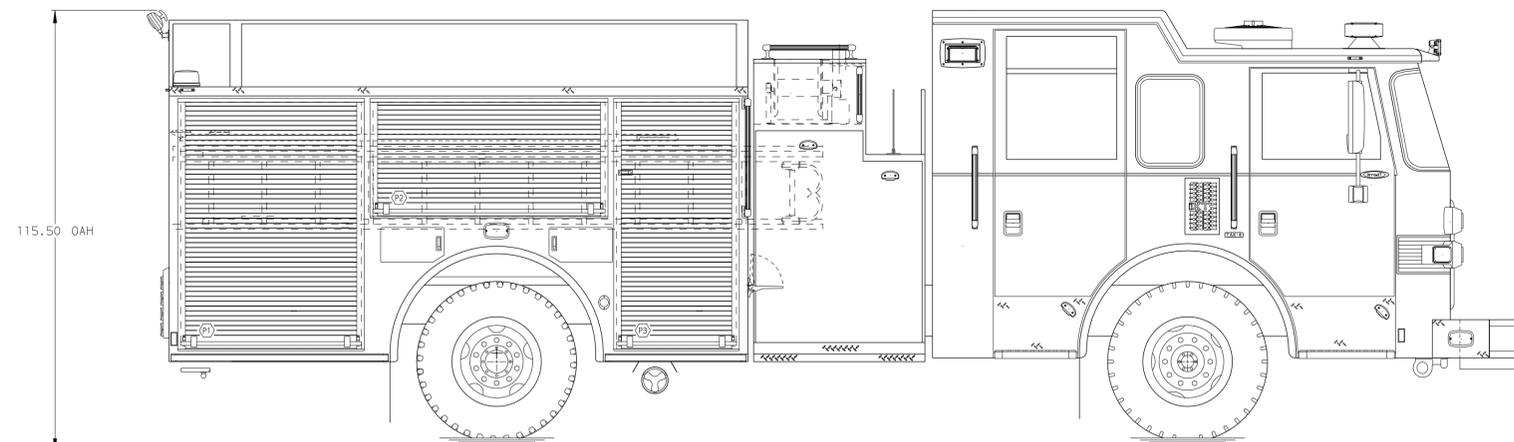

115.50 OAH

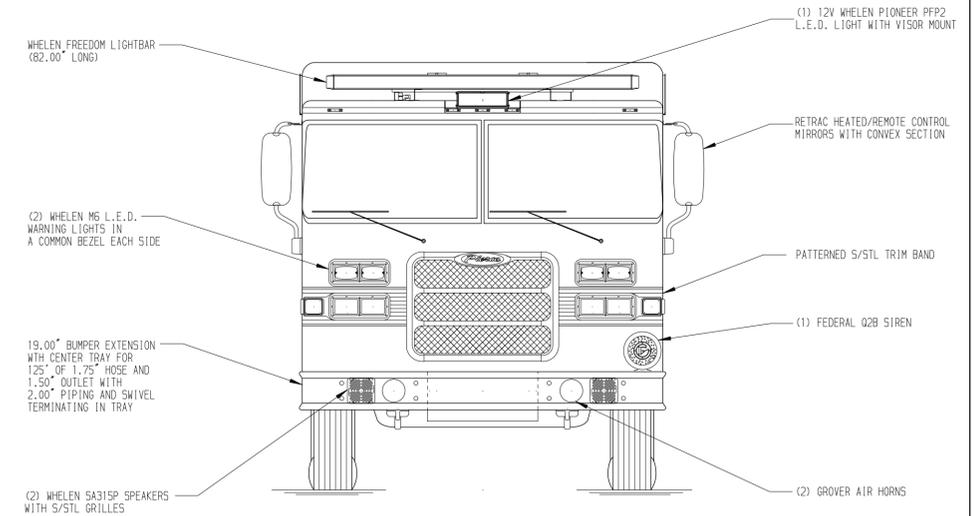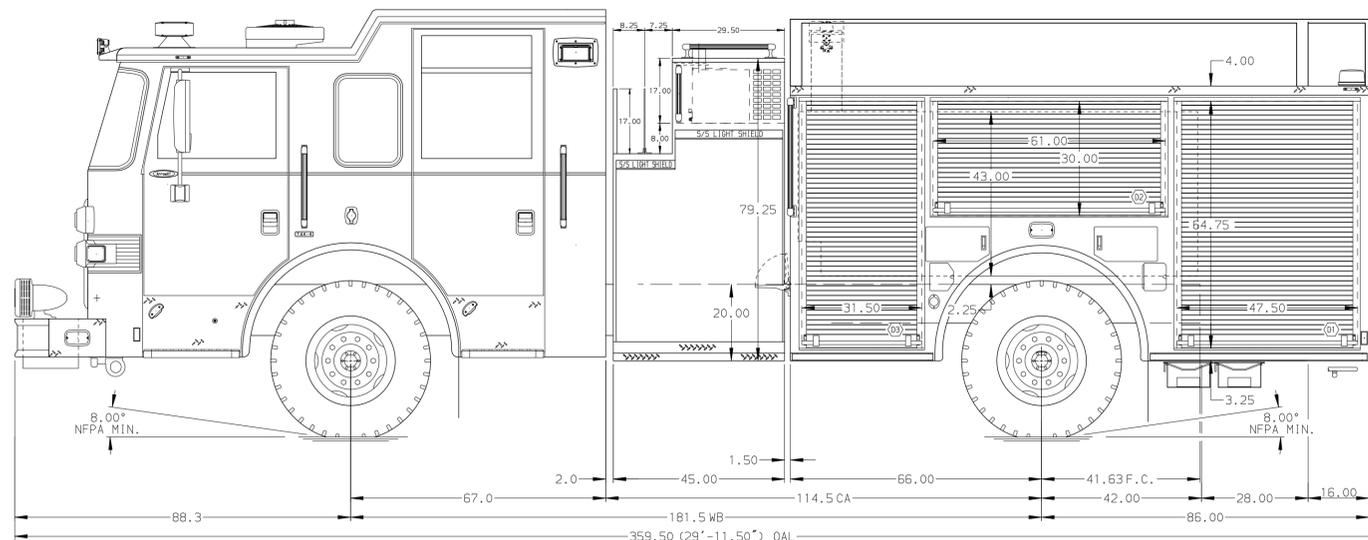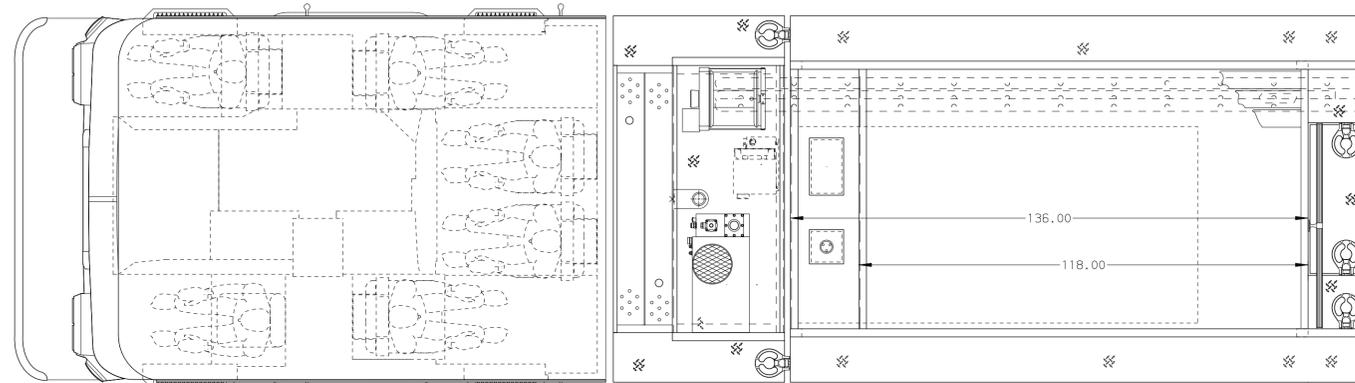

WHELEN FREEDOM LIGHTBAR (62.00" LONG)

(1) 12V WHELEN PIONEER PFP2 L.E.D. LIGHT WITH VISOR MOUNT

RETRACT HEATED/REMOTE CONTROL MIRRORS WITH CONVEX SECTION

(2) WHELEN M6 L.E.D. WARNING LIGHTS IN A COMMON BEZEL EACH SIDE

PATTERNED S/STL TRIM BAND


19.00" BUMPER EXTENSION WITH CENTER TRAY FOR 1.25" OF 1.75" HOSE AND 1.50" OUTLET WITH 2.00" PIPING AND SWIVEL TERMINATING IN TRAY

(1) FEDERAL Q28 SIREN

(2) WHELEN SA31SP SPEAKERS WITH S/STL GRILLES

(2) GROVER AIR HORNS

HOSEBED CAPACITY	
BED 1	500' OF 3.00" D.J. POLY HOSE
BED 2	1000' OF 5.00" D.J. POLY HOSE
BED 3	500' OF 3.00" D.J. POLY HOSE

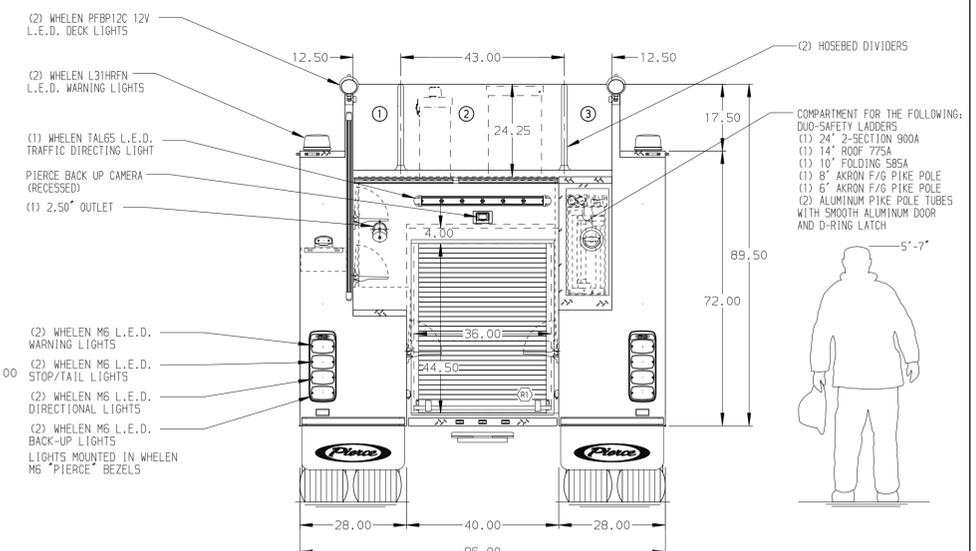

(2) WHELEN PFBP12C 12V L.E.D. DECK LIGHTS

(2) WHELEN L31HRFN L.E.D. WARNING LIGHTS

(1) WHELEN TALGS L.E.D. TRAFFIC DIRECTING LIGHT

PIERCE BACK UP CAMERA (RECESSED)

(1) 2.50" OUTLET

(2) WHELEN M6 L.E.D. WARNING LIGHTS

(2) WHELEN M6 L.E.D. STOP/TAIL LIGHTS


(2) WHELEN M6 L.E.D. DIRECTIONAL LIGHTS

(2) WHELEN M6 L.E.D. BACK-UP LIGHTS

LIGHTS MOUNTED IN WHELEN M6 "PIERCE" BEZELS

(2) HOSEBED DIVIDERS

COMPARTMENT FOR THE FOLLOWING:  
 DDO-SAFETY LADDERS  
 (1) 24' 2-SECTION 900A  
 (1) 14' ROOF 775A  
 (1) 10' FOLDING SB5A  
 (1) 8" AKRON F/G PIKE POLE  
 (1) 6" AKRON F/G PIKE POLE  
 (2) ALUMINUM PIKE POLE TUBES WITH SMOOTH ALUMINUM DOOR AND D-RING LATCH

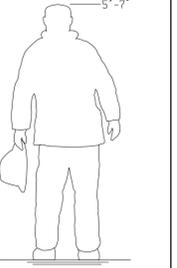

**NOTE**  
 DIMENSIONS SHOWN ARE APPROXIMATE AND ARE SUBJECT TO MINOR DEVIATIONS AS MAY OCCUR OR BE NECESSARY IN CONSTRUCTION.  
 MINOR DETAILS NOT SHOWN.

- ALUMINUM TREADPLATE EXTERIOR REAR WALL OF CAB
- MOUNTING BASES FOR ANTENNAS LOCATED PER SHOP ORDER
- S/STL SCUFFPLATE ON EACH CAB DOOR JAMB
- PERIMETER SCENE LIGHTS LOCATED PER SHOP ORDER
- PIERCE L.E.D. DUAL COMPARTMENT LIGHT STRIPS LOCATED PER SHOP ORDER
- PAINTED SHELF TRACKS LOCATED IN ALL BODY COMPARTMENTS
- ONE FULL WIDTH/DEPTH PAINTED ADJUSTABLE SHELF IN ALL BODY COMPARTMENTS
- ONE FLOOR MOUNTED SLIDE-OUT TRAY IN COMPARTMENT D1, D3, P1 & P3
- CIRCUIT BREAKER PANEL IN COMPARTMENT D3
- PIERCE LOGO MIDLAPS FRONT AND REAR
- S/STL FENDER CROWNS FRONT AND REAR
- BATTERY CHARGER LOCATED IN COMPARTMENT D3
- BATTERY CHARGE INDICATOR LOCATED NEAR D.S. SEAT RISER WITH BRACKET
- S/STL DRIP PAN/GUARD FOR ALL ROLL-UP DOORS
- MOUNTING PROVISIONS FOR FRONT INLET
- PLUMBING FOR FUTURE FOAM SYSTEMS PER SHOP ORDER
- MOUNTING PROVISIONS FOR WILL-BURST NIGHT SCAN POWERLITE MS 3.0 10'
- AIR INLET WITH DISCONNECT FITTING LOCATED IN D.S. STEP WELL
- ONE AKRON ELECTRIC REWIND CORD REEL MODEL ERWC-15-10 FOR 200' OF 10/4 CABLE LOCATED IN THE CARGO AREA

		CHASSIS DATA		TITLE	ARROW-XT	JOB NO.	28886
		PIERCE		FOR	PIERCE STOCK APPLETON, WI	SCALE	1:24
		MODEL		DWG NO.	28886AD	DRAWN BY	DDO
REV	DATE	BY	CH	ARROW XT		CHECKED BY	DST
							17FEB15
						SHEET SIZE	D
						SHEET NO.	1 OF 1

